



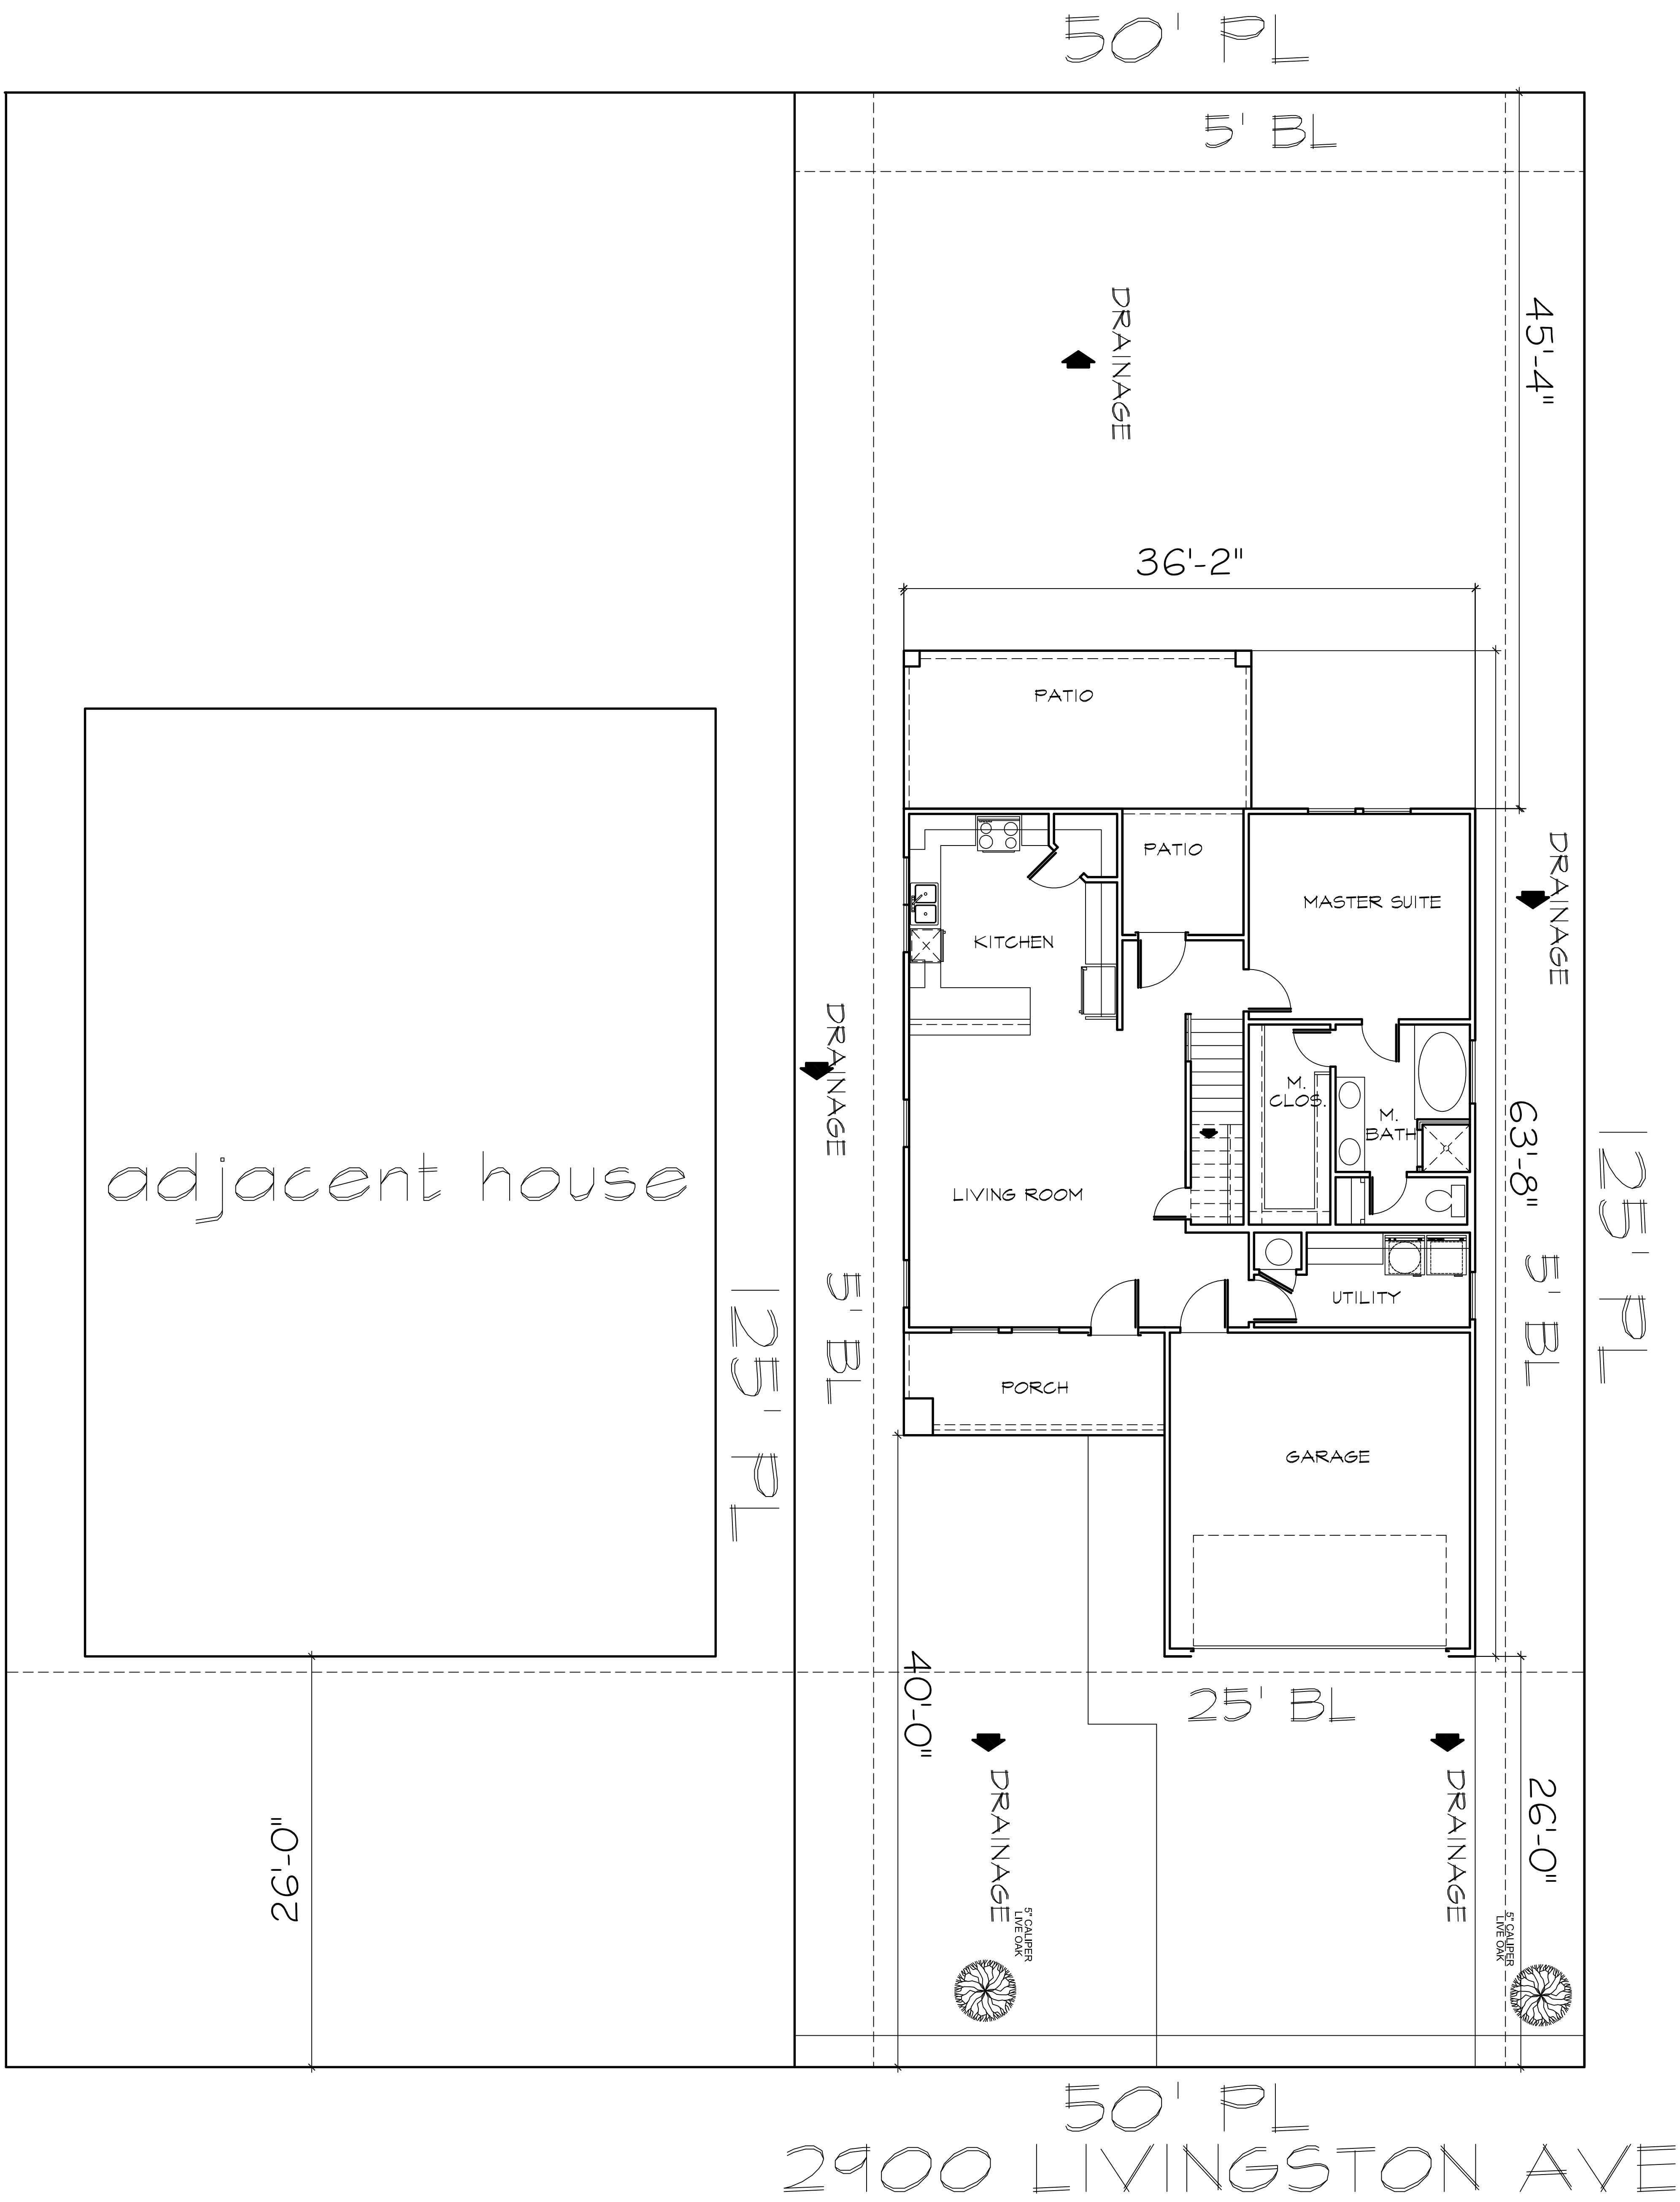


LOT:	BLK:	24-12
ADDRESS:	2900 LIVINGSTON AVE	
SUBDIVISION:	PROSPECT HEIGHTS	
CITY:	FORT WOTH	
COUNTY:	TARRANT	
STATE:	TX	
SCALE:	NTS	

GOLDEN STAR ROCK
INVESTMENTS

Doug Herron.com
Residential Designs
817-538-2910

  
EMAIL: dougsplans@aol.com WEBSITE: dougherron.com



2

LOT:	BLK:	
ADDRESS:		
SUBDIVISION:		
CITY:		FORT WOTH
COUNTY:		TARRANT
STATE:		TX
SCALE:		1/4"

EMAIL: dougsplans@aol.com WEBSITE: dougherron.com

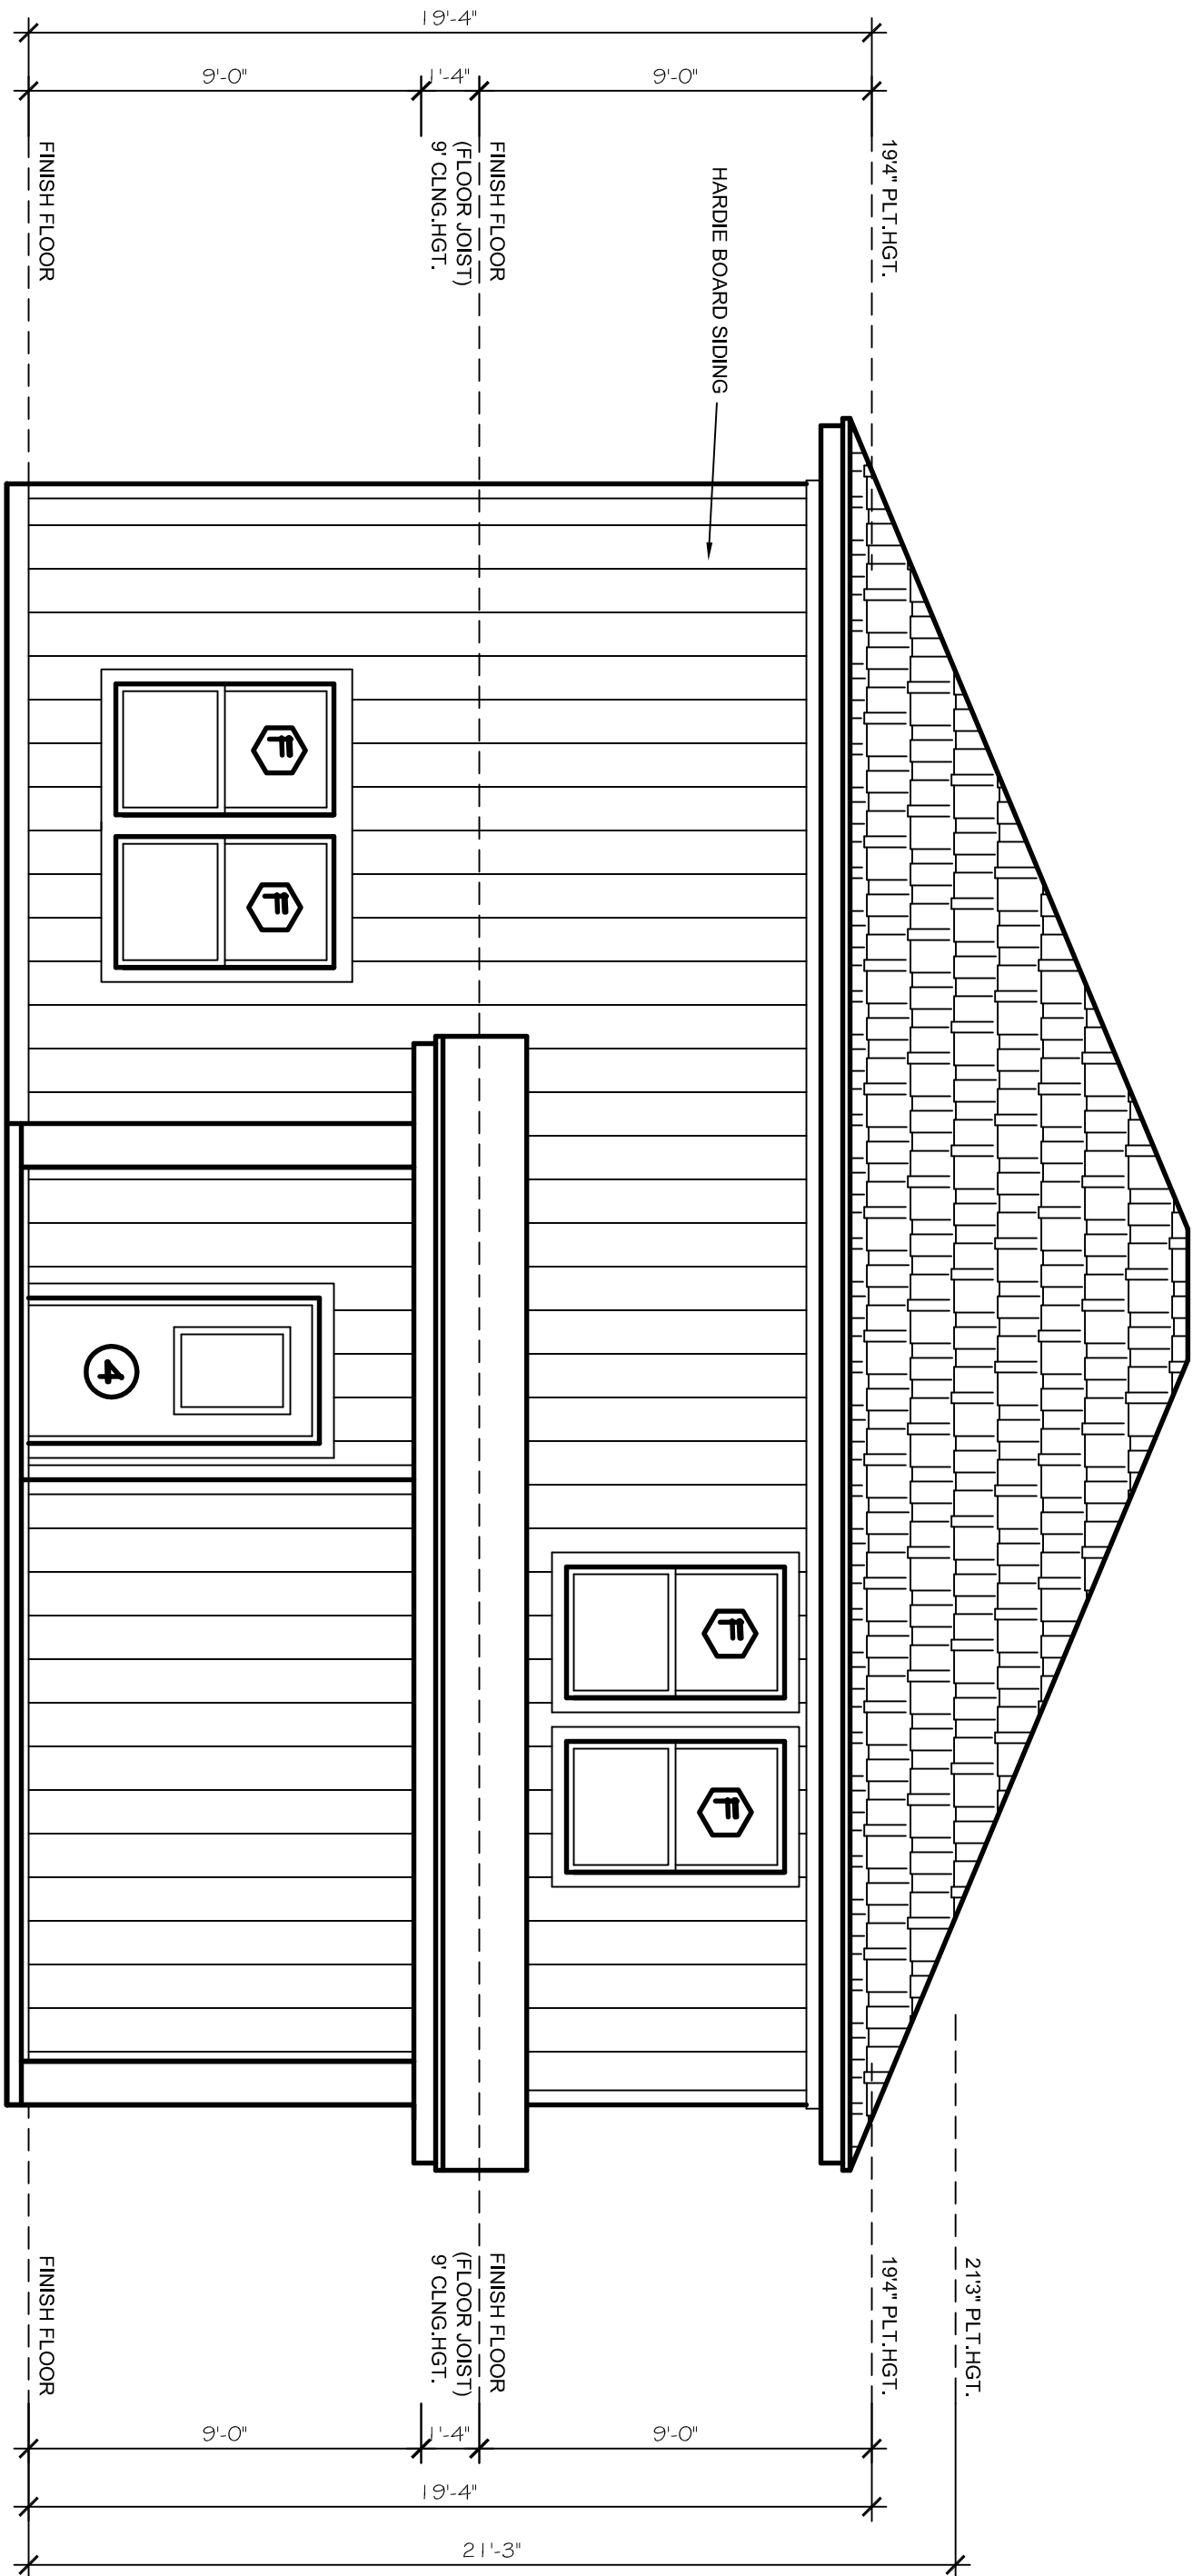

Doug Herron.com
Residential Designs
817-538-2910


EMAIL: dougsplans@aol.com WEBSITE: dougherron.com

LOT:	BLK:
ADDRESS:	
SUBDIVISION:	
CITY:	FORT WOTH
COUNTY:	TARRANT
STATE:	TX
SCALE:	1/4"

GOLDEN STAR ROCK
INVESTMENTS


038-2427-0624
REV/PATIO

3

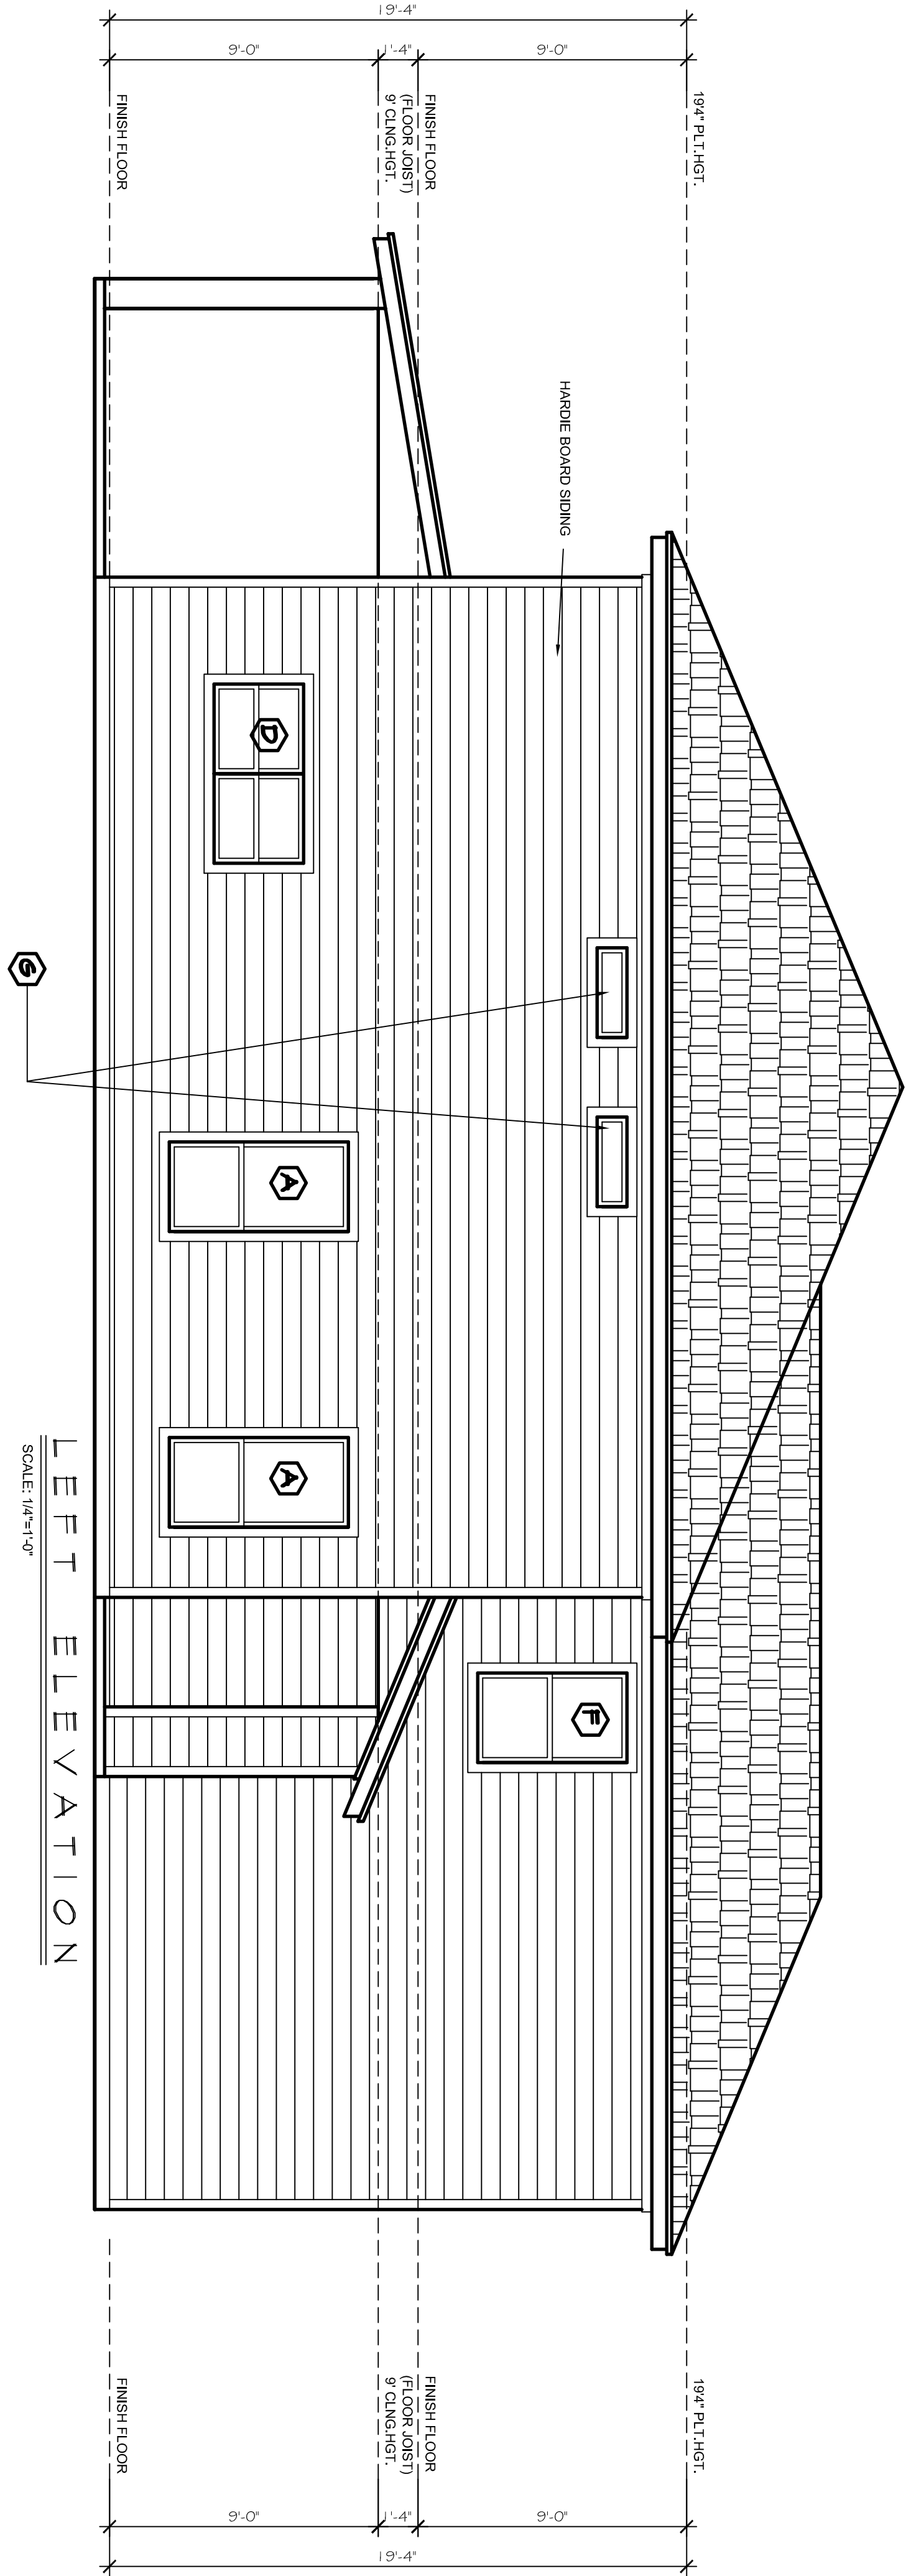

LEFT ELEVATION

SCALE: 1/4"=1'-0"

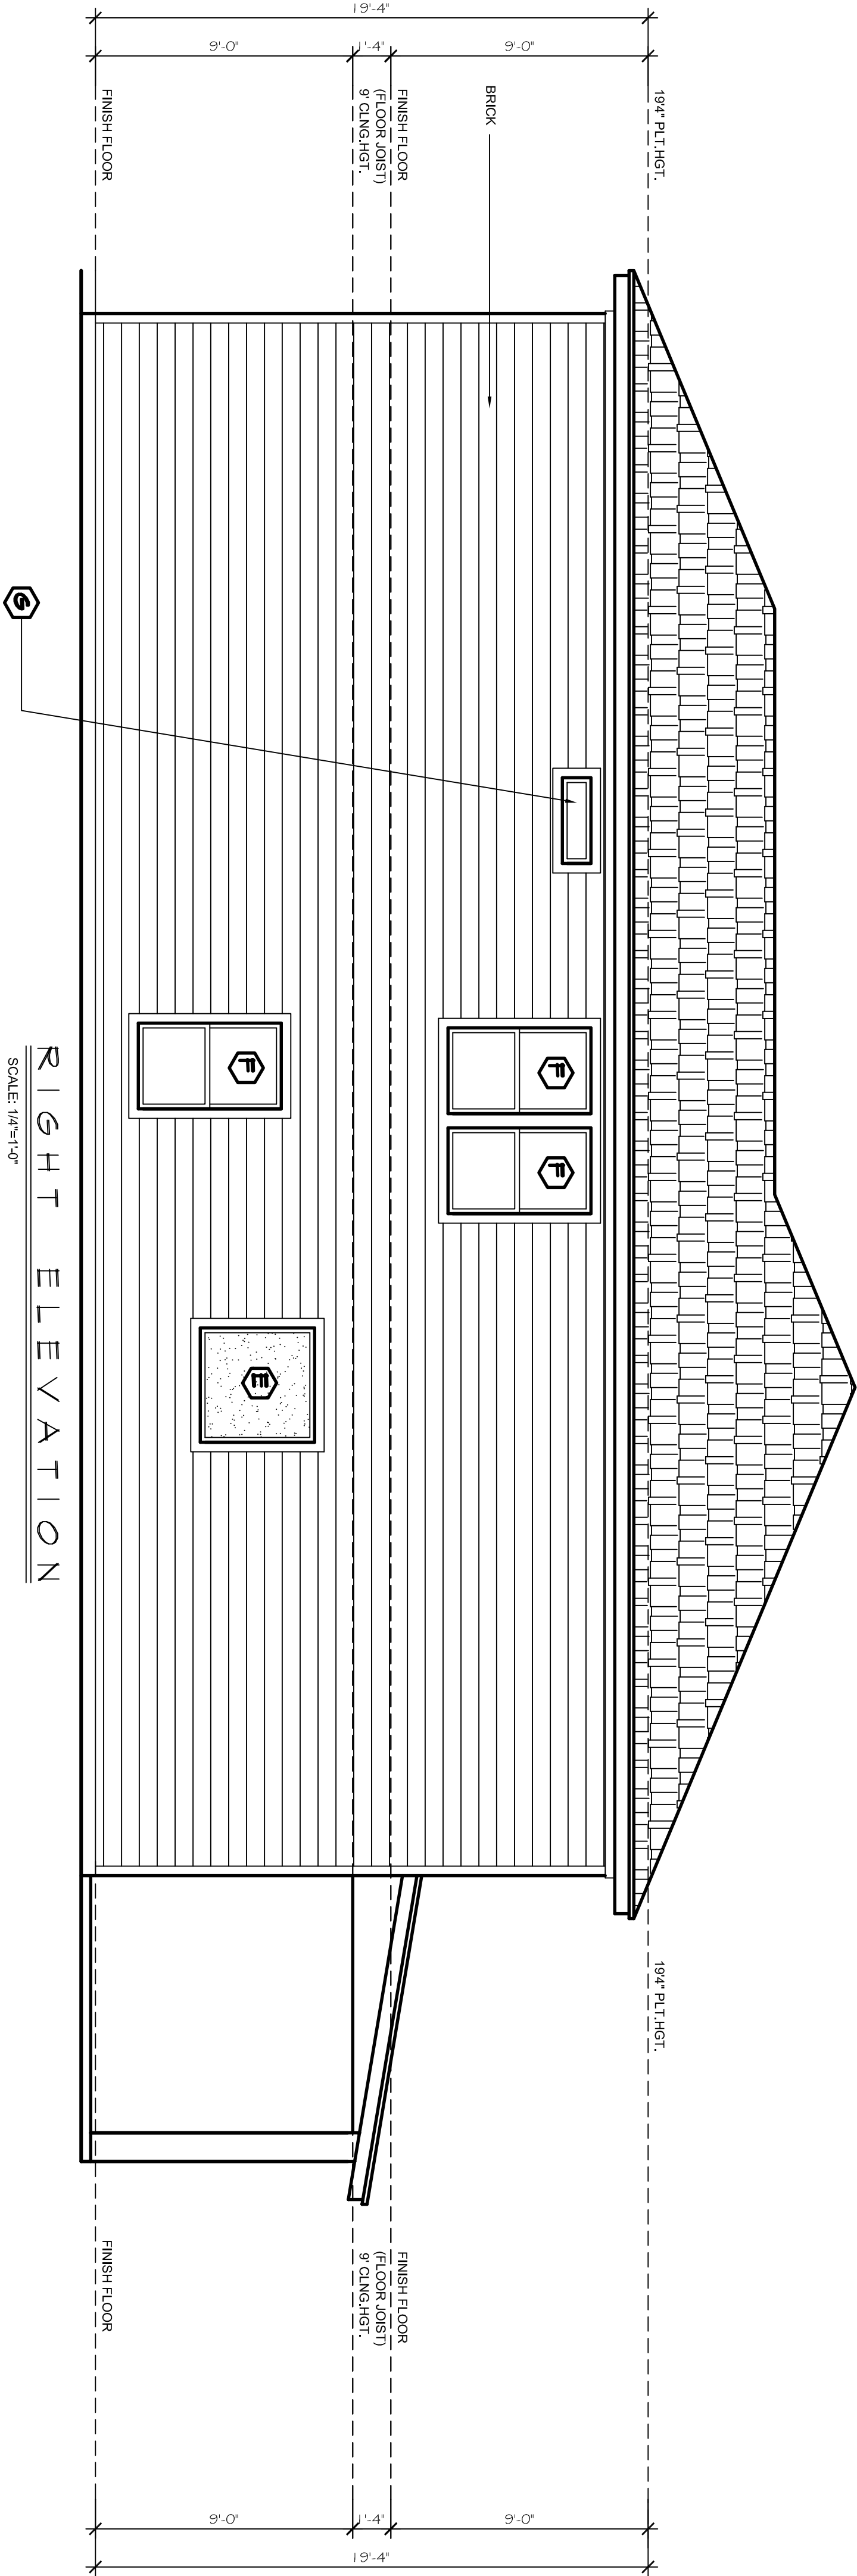

RIGHT ELEVATION



SCALE: 1/4"=1'-0"

LOT:	BLK:
ADDRESS:	
SUBDIVISION:	
CITY:	FORT WOTH
COUNTY:	TARRANT
STATE:	TX
SCALE:	1/4"

GOLDEN STAR ROCK
INVESTMENTS

Doug Herron.com
Residential Designs
817-538-2910

EMAIL: dougsplans@aol.com WEBSITE: dougherron.com

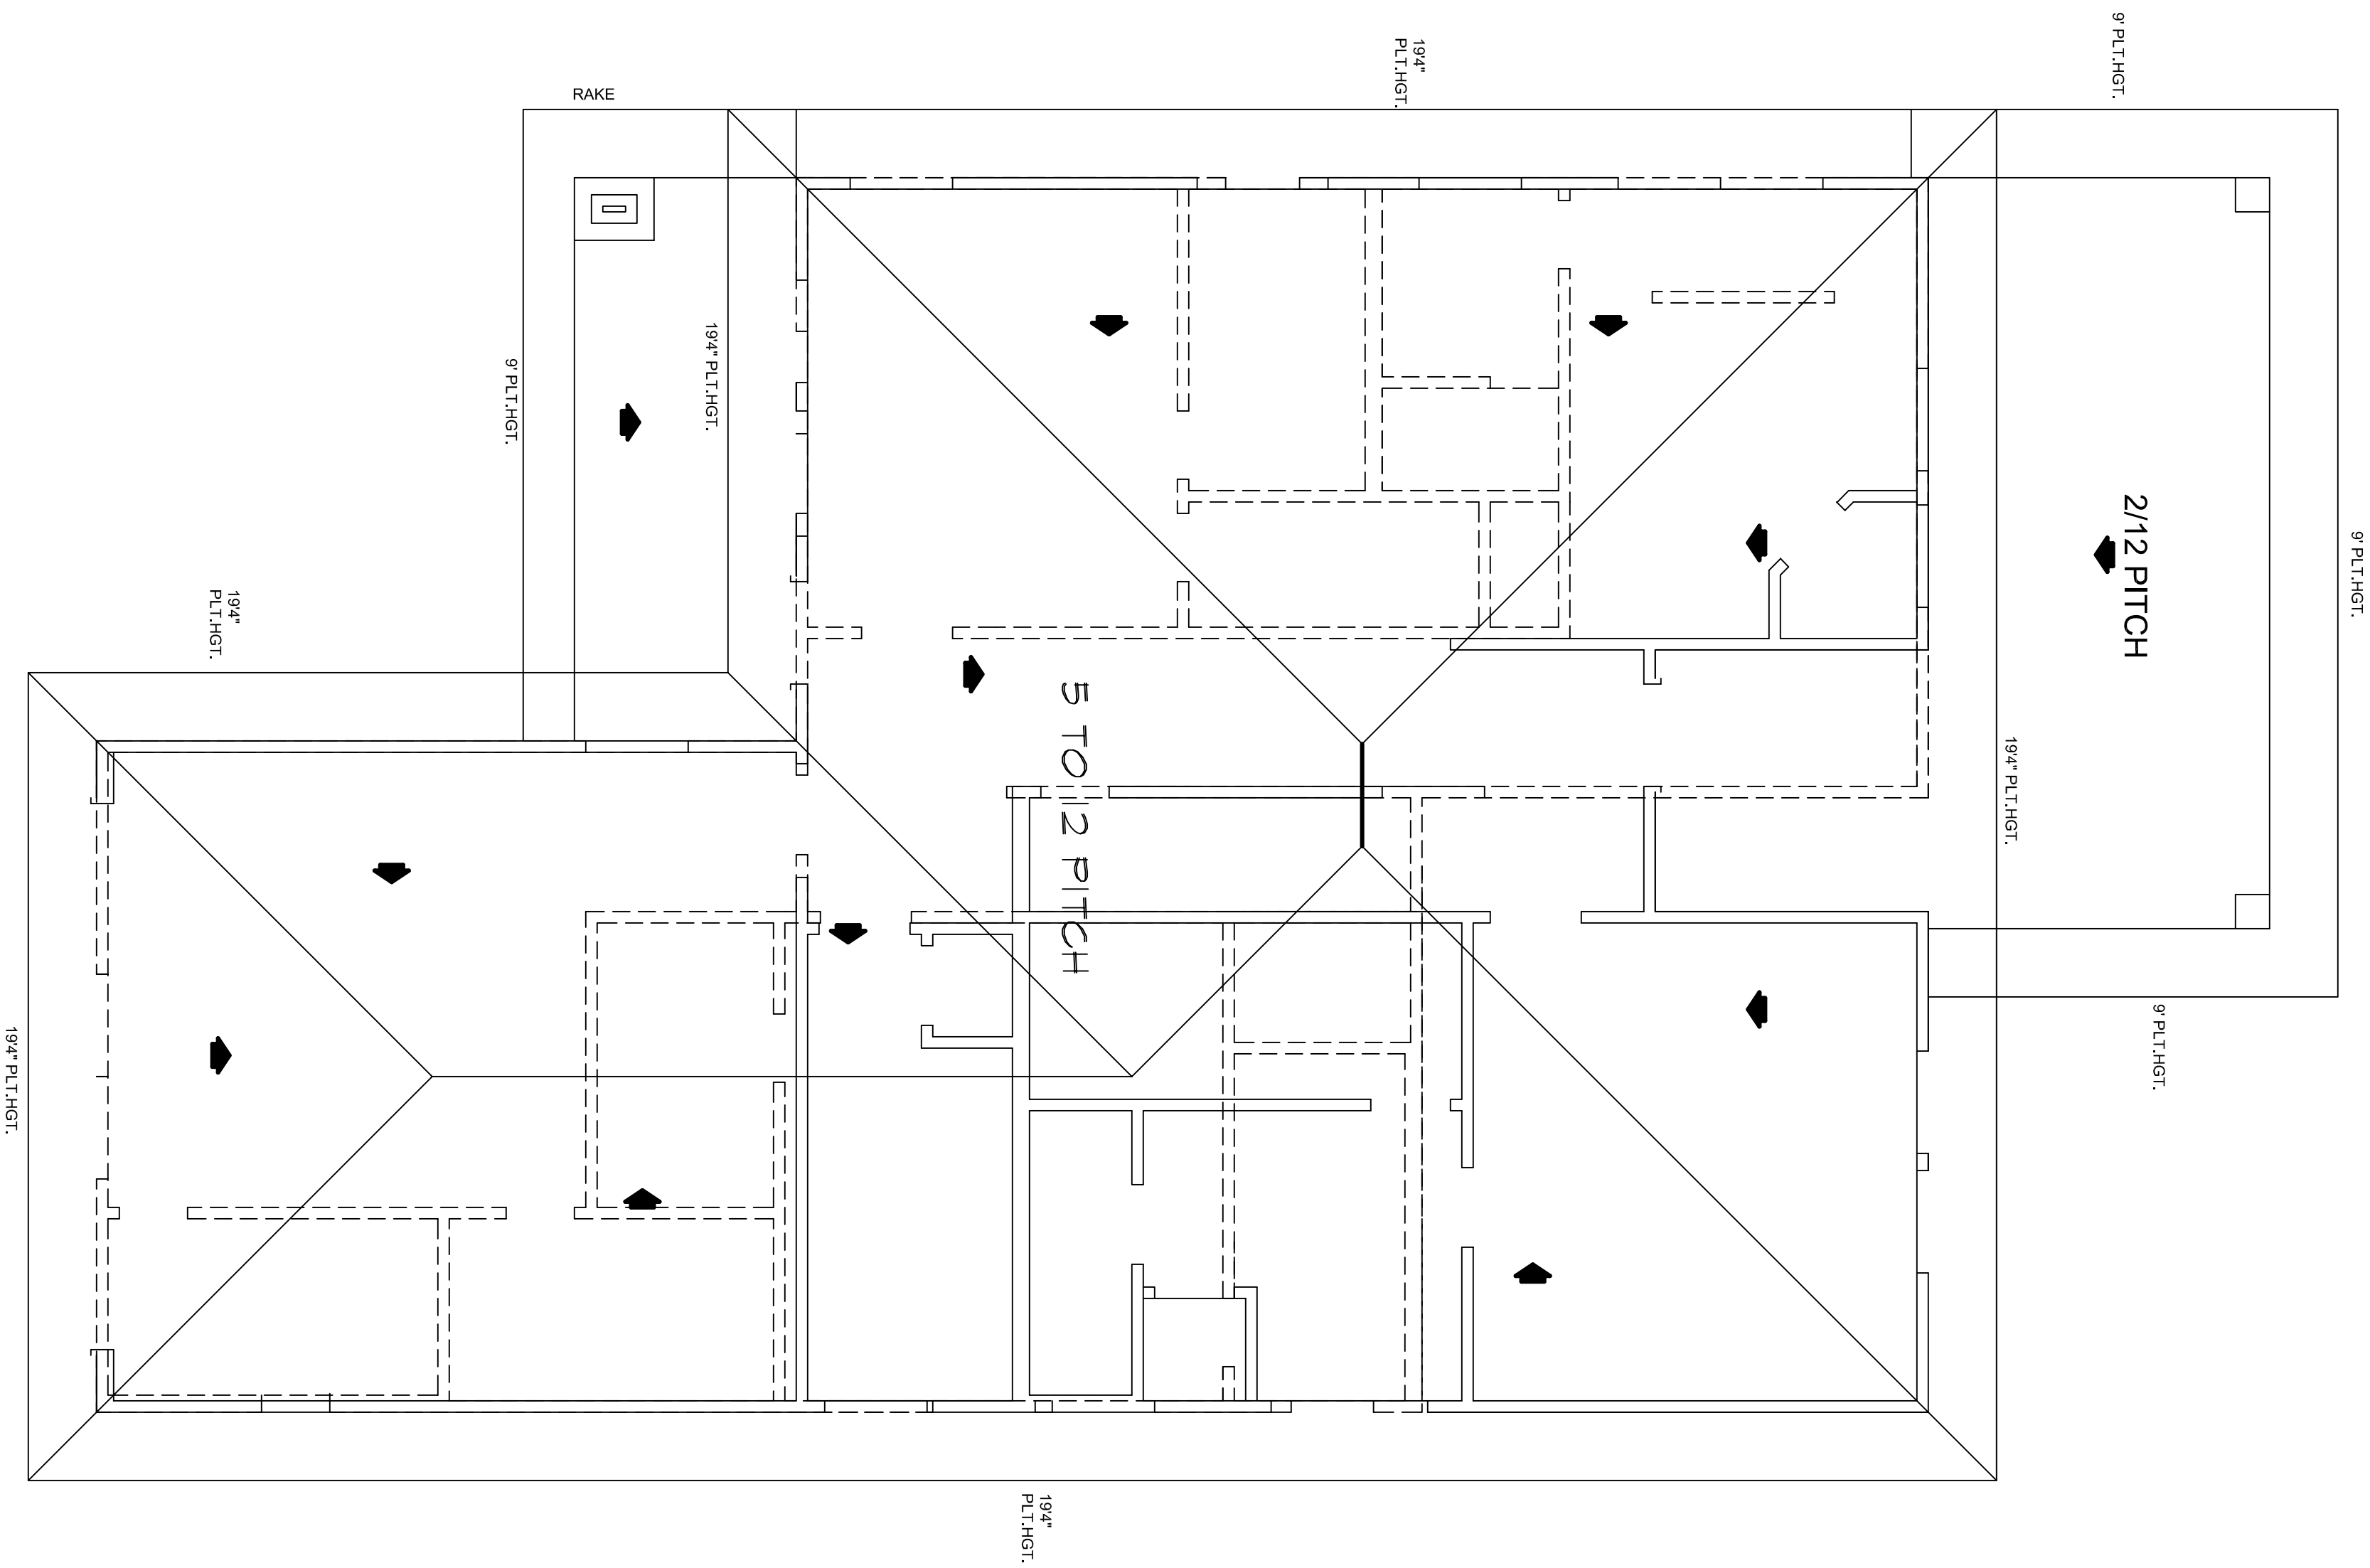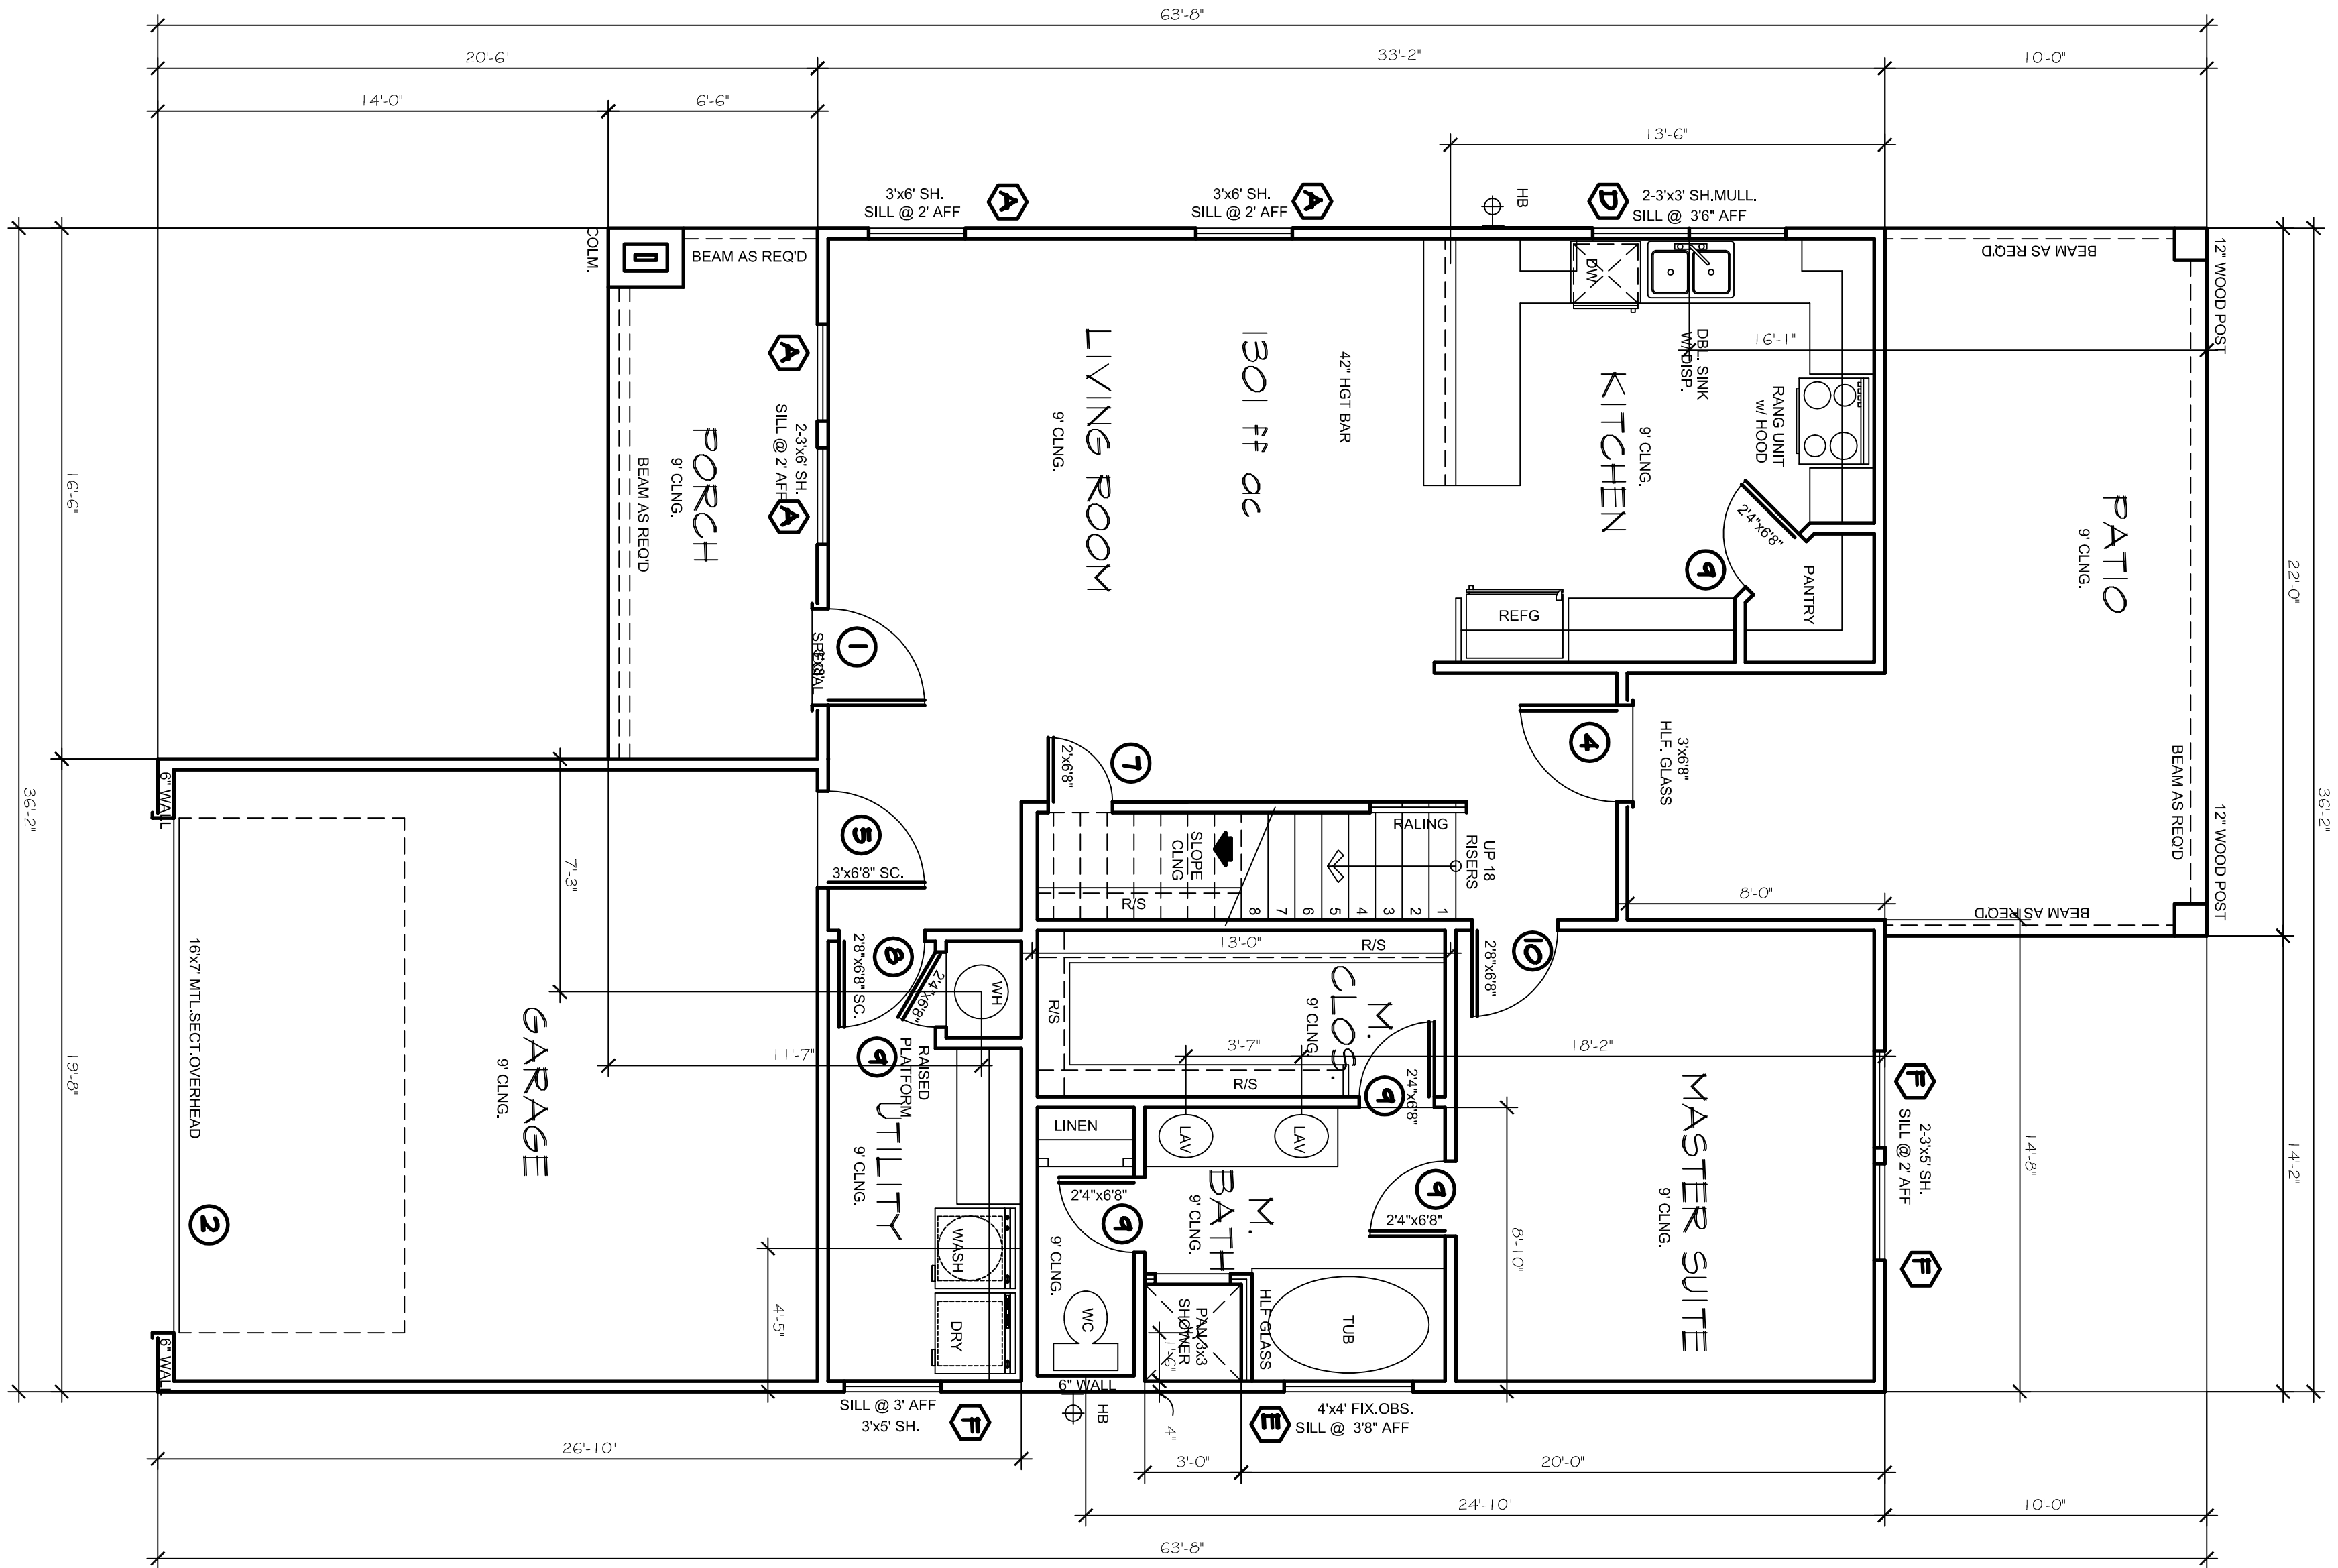


LOT:	BLK:
ADDRESS:	
SUBDIVISION:	
CITY:	FORT WOTH
COUNTY:	TARRANT
STATE:	TX
SCALE:	1/4"

GOLDEN STAR ROCK
INVESTMENTS

Doug Herron.com
Residential Designs
817-538-2910


EMAIL: dougsplans@aol.com WEBSITE: dougherron.com

ELECTRICAL SCHEDULE	
	BLOCK FOR OPTIONAL CEILING FAN w/ LIGHT KIT
	RECESSED INCANDESCENT
	RECESSED SPOT
	CEILING MOUNTED FIXTURE
	WALL MOUNTED FIXTURE/COACH LIGHT
	UNDER CABINET FLUORESCENT
	OVERHEAD PULL CHAIN
	EXHAUST FAN WITH LIGHT
	DOUBLE FLOOD LIGHTS
	SWITCH
	SWITCH WITH DIMMER
	110-VOLT OUTLET
	220-VOLT OUTLET
	WEATHERPROOFED GROUNDED 110-VOLT
	GROUNDED 110-VOLT OUTLET
	1/2 HOT 110-VOLT OUTLET
	CEILING 110-VOLT OUTLET
	FLOOR 110-VOLT OUTLET AND/OR UNDER
	PHONE
	TV CABLE
	SMOKE CARBON DETECTOR
	INTERCOM/SPEAKER
	MASTER INTERCOM/SPEAKER
	ELECTRIC EYE
	SECURITY KEY PAD
	DOORBELL
	CHIME
	GAS HOOK-UP
	HOSE BIBB
	ELECTRICAL PANELS

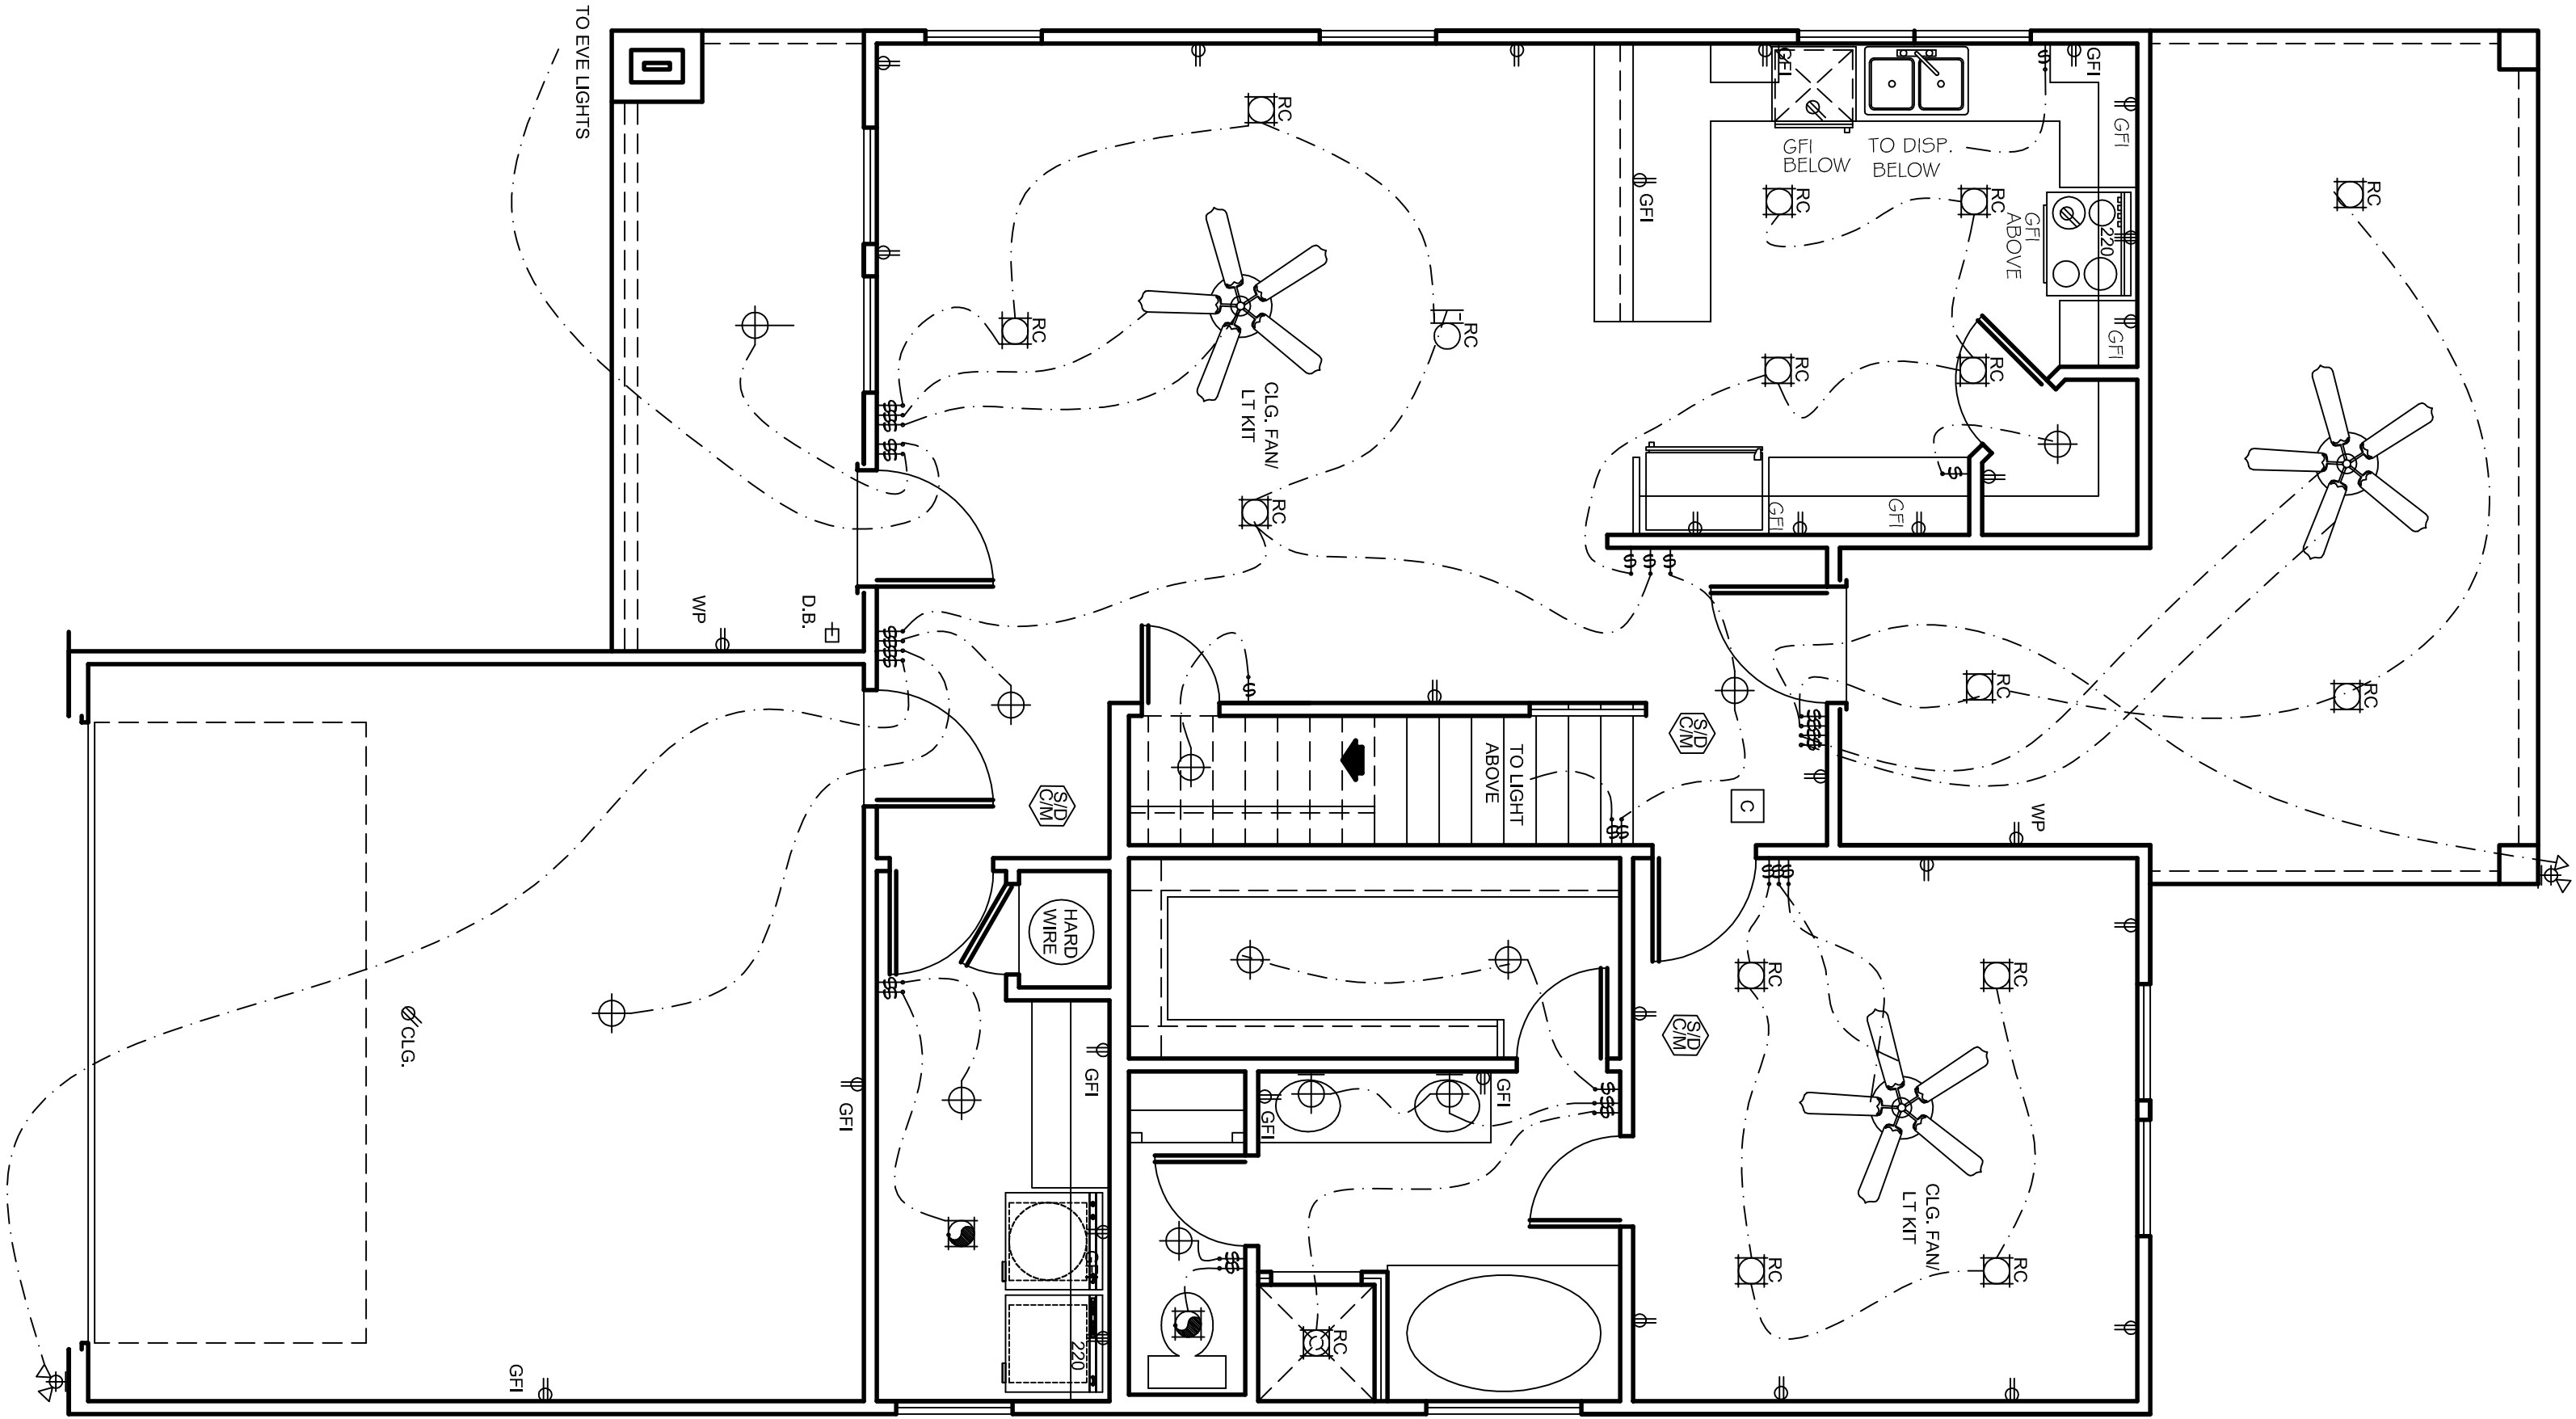

FIRST FLOOR ELECTRIC PLAN

SCALE: 1/4"=1'-0"

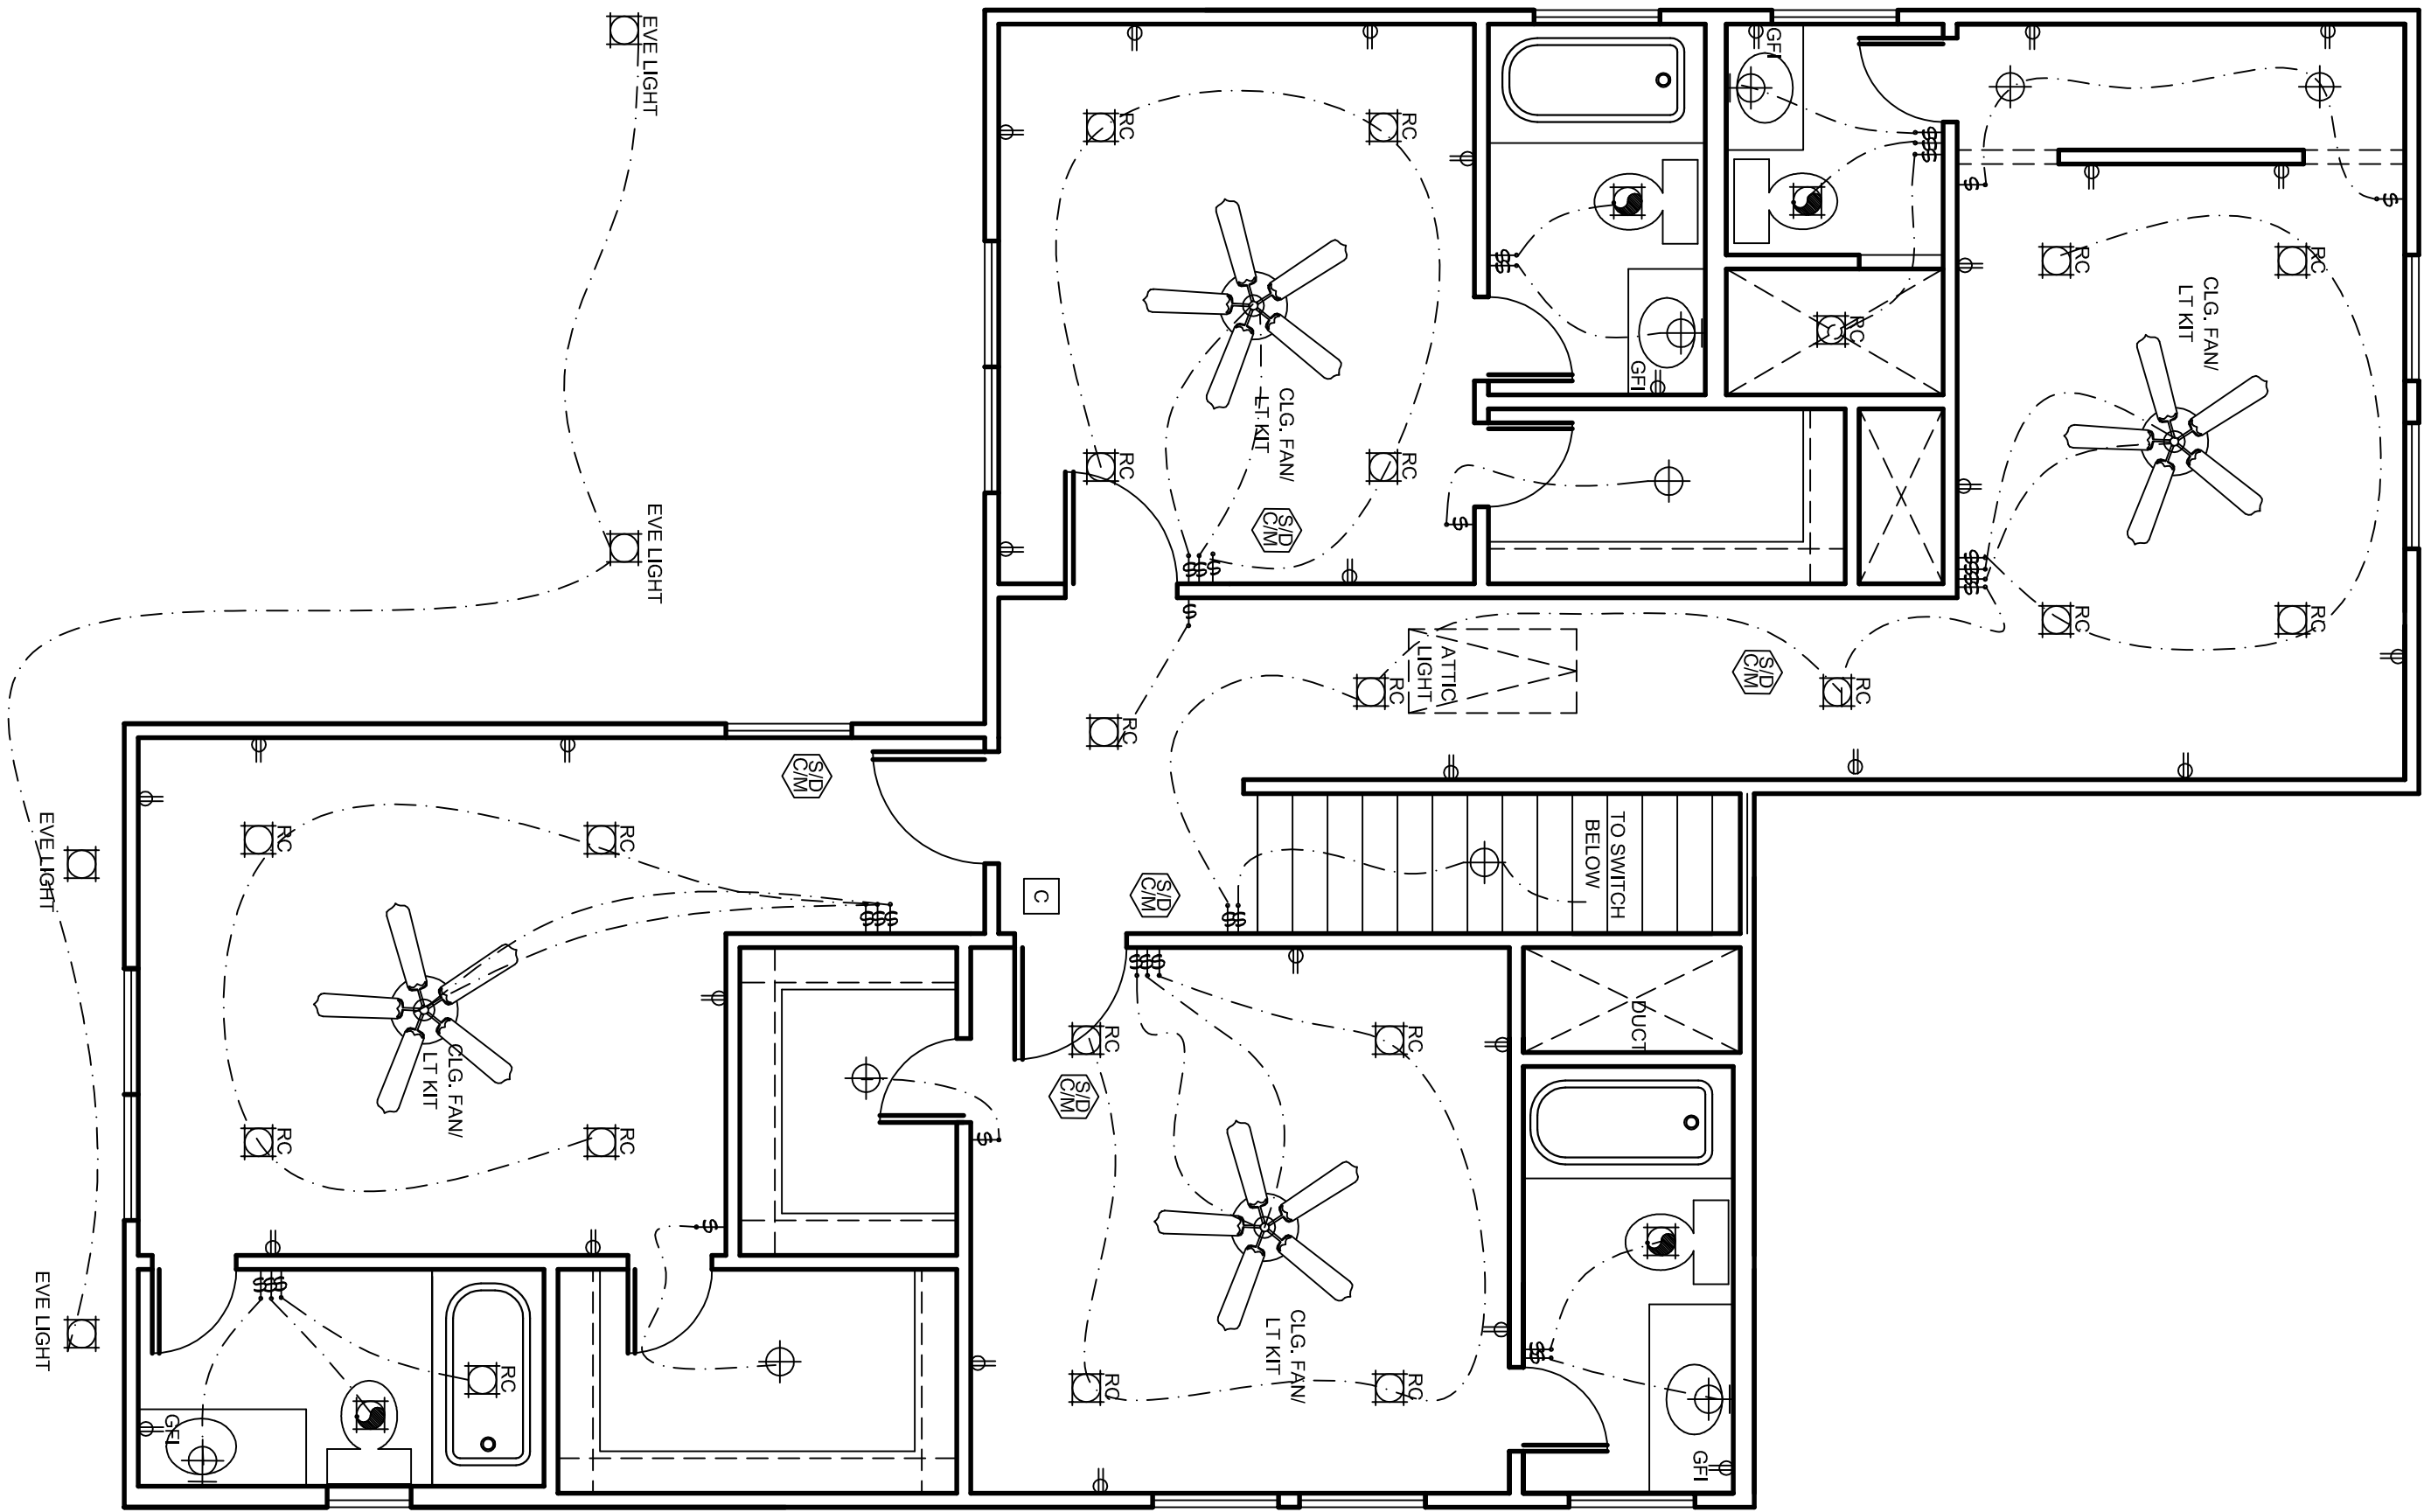

SECOND FLOOR ELECTRIC PLAN

SCALE: 1/4"=1'-0"

Doug Herron.com
Residential Designs
817-538-2910

EMAIL: dougsplans@aol.com WEBSITE: dougherron.com

LOT:	BLK:
ADDRESS:	
SUBDIVISION:	
CITY:	FORT WOTH
COUNTY:	TARRANT
STATE:	TX
SCALE:	1/4"

GOLDEN STAR ROCK
INVESTMENTS

7/11/24
038-2427-0624
REV/PATIO

6